

CODE ANALYSIS NOTES

APPLICABLE CODES: 2018 INTERNATIONAL BUILDING CODE

USE GROUP: A-3 GYMNASIUM, SEPARATED

CONSTRUCTION: 2B - NON-COMBUSTIBLE, UNPROTECTED (METAL STUDS AND STEEL PEMB PRIMARY STRUCTURE)

BUILDING FOOTPRINT: 1,050 SF (ENTRY VESTIBULE)
31,000 SF (MAIN STRUCTURE)
32,050 SF (TOTAL ACTUAL)

MAX. ALLOW. FOOTPRINT: 38,000 SF (FULLY-SPRINKLED)
7,125 SF (FRONTAGE INCREASE)
45,125 SF (MAX. ALLOW. FOOTPRINT)

MAX. OCCUPANT LOAD:

GYM	4,930 SF	1 PER 50	99 PEOPLE
PITCH/HIT	3,740 SF	ACTUAL	12 PEOPLE
BASKETBALL	8,395 SF	ACTUAL	40 PEOPLE
BASEBALL	12,285 SF	ACTUAL	29 PEOPLE
OFFICE	295 SF	1 PER 150	2 PEOPLE
CONCESSION	690 SF	1 PER 200	4 PEOPLE
STORAGE	405 SF	1 PER 300	2 PEOPLE
NON-OCCUPIABLE	1,320 SF	N/A	N/A
TOTAL	32,050 SF		179 PEOPLE

PLUMBING FIXTURES:

TOILETS: 90 MEN / 125 = 1 REQ'D, 4 FIXTURES PROVIDED
90 WOMEN / 65 = 2 REQ'D, 4 TOILETS PROVIDED

LAVATORIES: 90 / 200 = 1 REQ'D, 2 SINKS PROVIDED

DRINKING FOUNTAIN: 1 PER 500, 1 REQ'D, 1 PROVIDED

SERVICE SINK: 1 REQUIRED, 1 PROVIDED

FIRE SPRINKLERS: NOT REQUIRED PER CITY ORDINANCE

FIRE ALARM: REQUIRED

WALL RATING LEGEND

---	1-HR FIRE RATING
-.-.-	2-HR FIRE RATING
---	3-HR FIRE RATING

GENERAL NOTES


1. NON-RATED ASSEMBLIES ARE NOT TO PENETRATE RATED ASSEMBLIES
2. ALL RATED PARTITIONS SHALL CONTINUE TO UNDERSIDE OF DECK AND BE SEALED WITH APPROPRIATE FIRE-CAULKING. ALL PENETRATIONS SHALL BE SEALED WITH APPROPRIATE FIRE-CAULKING
3. ALL SMOKE PARTITIONS SHALL CONTINUE TO UNDERSIDE OF STRUCTURE AND BE SEALED WITH APPROPRIATE CAULKING. ALL PENETRATIONS SHALL BE SEALED WITH APPROPRIATE CAULKING
4. ADA EXIT SIGNAGE SHALL COMPLY WITH IBC 1110.3.2

LIFE SAFETY LEGEND

AREA NAME XXX SF / XX CDF XXX CDF	AREA (SF)
	LOAD FACTOR
	OCCUPANCY LOAD
-----	EGRESS ROUTE
↑ XXXX	EGRESS (CALCULATED)
↑ XXXX	EGRESS (CAPACITY)
●	POINT AT WHICH TWO SEPARATE PATHS OF EGRESS ARE AVAILABLE

1 LIFE-SAFETY PLAN
SCALE: 1/8" = 1'-0"

<p>PROJECT NO. 25142618</p> <p>DRAWING NO. A-002</p>	<p>CITY OF HOUSTON BALLPARK QUADPLEX PROJECT</p> <p>LIFE-SAFETY PLAN</p>		<p style="text-align: center;">ARCHER-ELGIN</p> <p style="text-align: center;">ENGINEERING SURVEYING ARCHITECTURE</p> <p style="text-align: center; font-size: small;">CM Archer Group, P.C. dba: Archer-Elgin Corporate Authority: 310 East 40th Street, Suite 1000, Houston, TX 77002 E: 281.264.6022 F: 281.264.6023 www.archer-elgin.com</p>								
<p>THIS DRAWING IS PRELIMINARY AND NOT FOR CONSTRUCTION. IT IS THE RESPONSIBILITY OF THE USER TO OBTAIN ALL NECESSARY PERMITS AND APPROVALS FROM LOCAL, STATE, AND FEDERAL REGULATORY AGENCIES.</p>											
<table border="1" style="width: 100%; border-collapse: collapse;"> <thead> <tr> <th style="width: 50%;">NO.</th> <th style="width: 30%;">DATE</th> <th style="width: 20%;">BY</th> <th style="width: 10%;">REVISION BLOCK</th> </tr> </thead> <tbody> <tr> <td> </td> <td> </td> <td> </td> <td> </td> </tr> </tbody> </table>				NO.	DATE	BY	REVISION BLOCK				
NO.	DATE	BY	REVISION BLOCK								
<p>DESIGNED/DRAWN BY: JK DATE: 2/11/2026</p> <p>REVISIONS: NONE</p>											

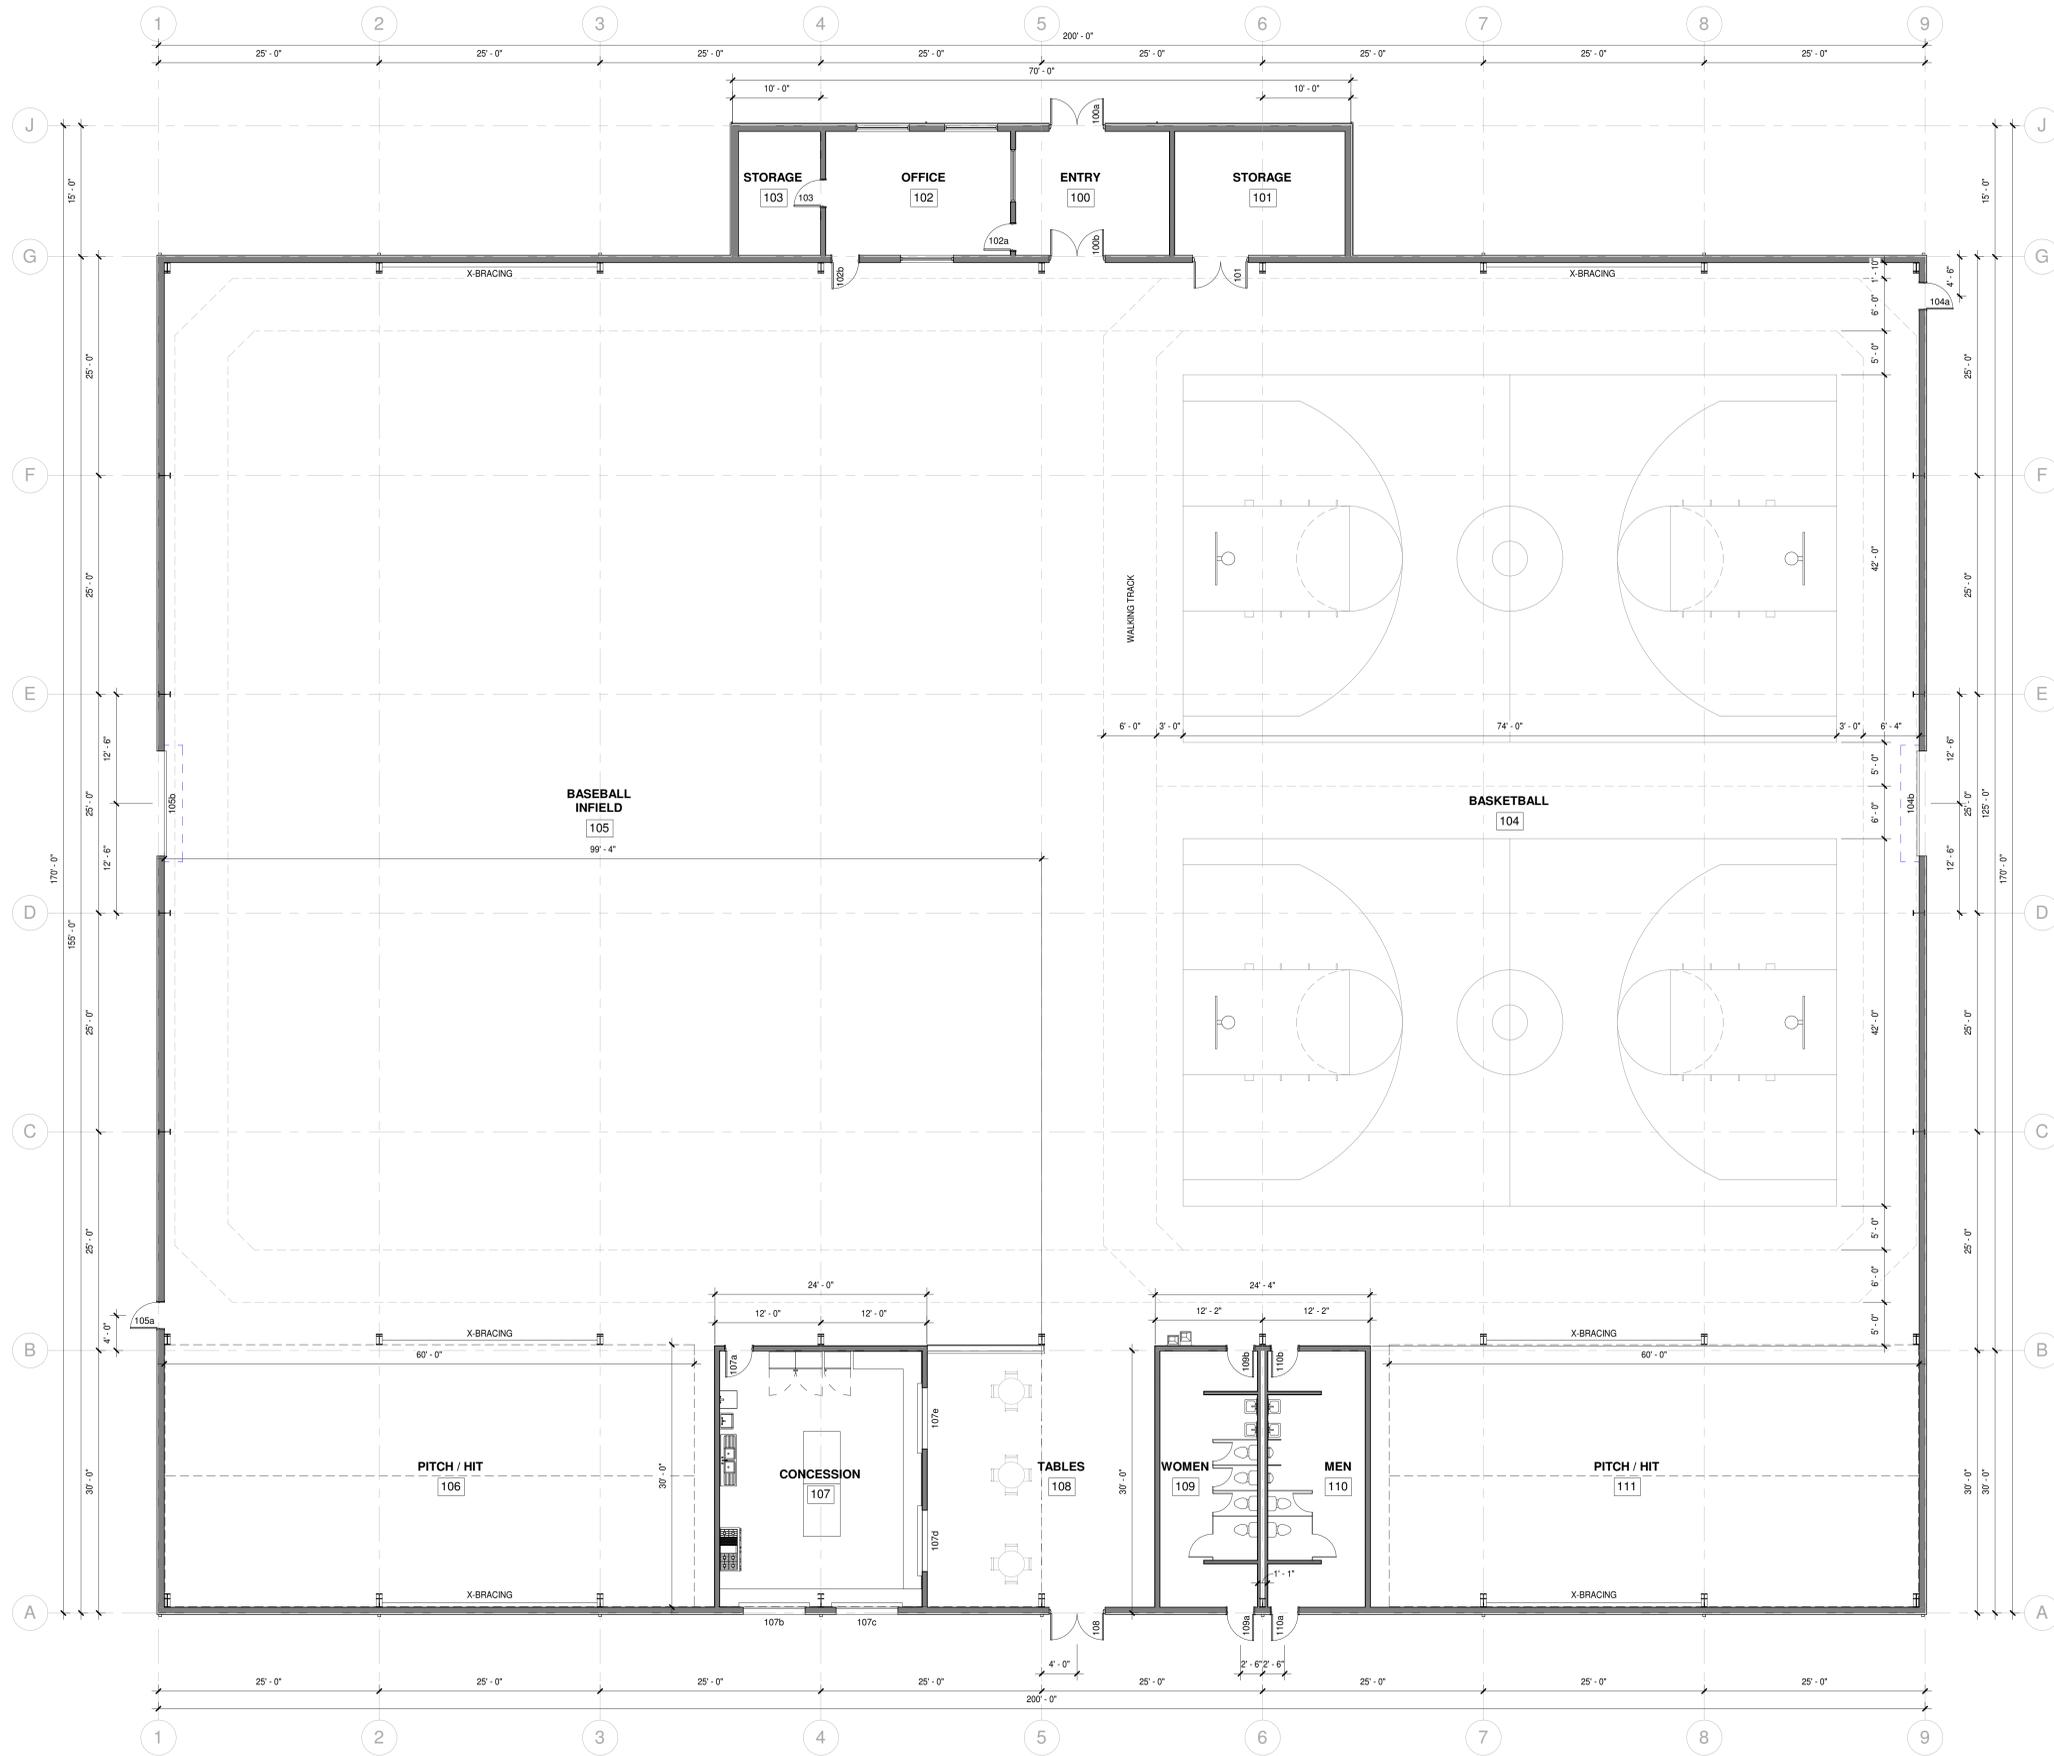


1 FLOOR PLAN
SCALE: 1/8" = 1'-0"

- Preliminary, not for construction, recording purposes or implementation.
 - Final, intended copy, not for construction, recording purposes or implementation.
 DESIGNED/DRAWN BY: JK DATE: 2/11/2026

No.	DATE	BY	REVISION BLOCK


PRELIMINARY DRAWINGS FOR REVIEW AND APPROVAL PURPOSES ONLY. FINAL PLANS WILL BE SIGNED, SEALED, AND APPROVED BY THE ARCHITECT. APPROVALS FROM LOCAL, STATE, AND FEDERAL REGULATORY AGENCIES.

CM Archer Group, P.C. dba: **ARCHER-ELGIN**
 ENGINEERING | SURVEYING | ARCHITECTURE
 Corporate Authority:
 CM Archer Group, P.C. • E: 2003023812.LS.2004017577.D.A.2019011719
 310 East 4th Street (Ball, Missouri 63001) • Phone: 314.564.6062 • www.archer-elgin.com

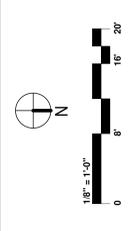


CITY OF HOUSTON
 BALLPARK QUADPLEX PROJECT
 FLOOR PLAN

PROJECT NO:
 25142618
 DRAWING NO:
 A-101

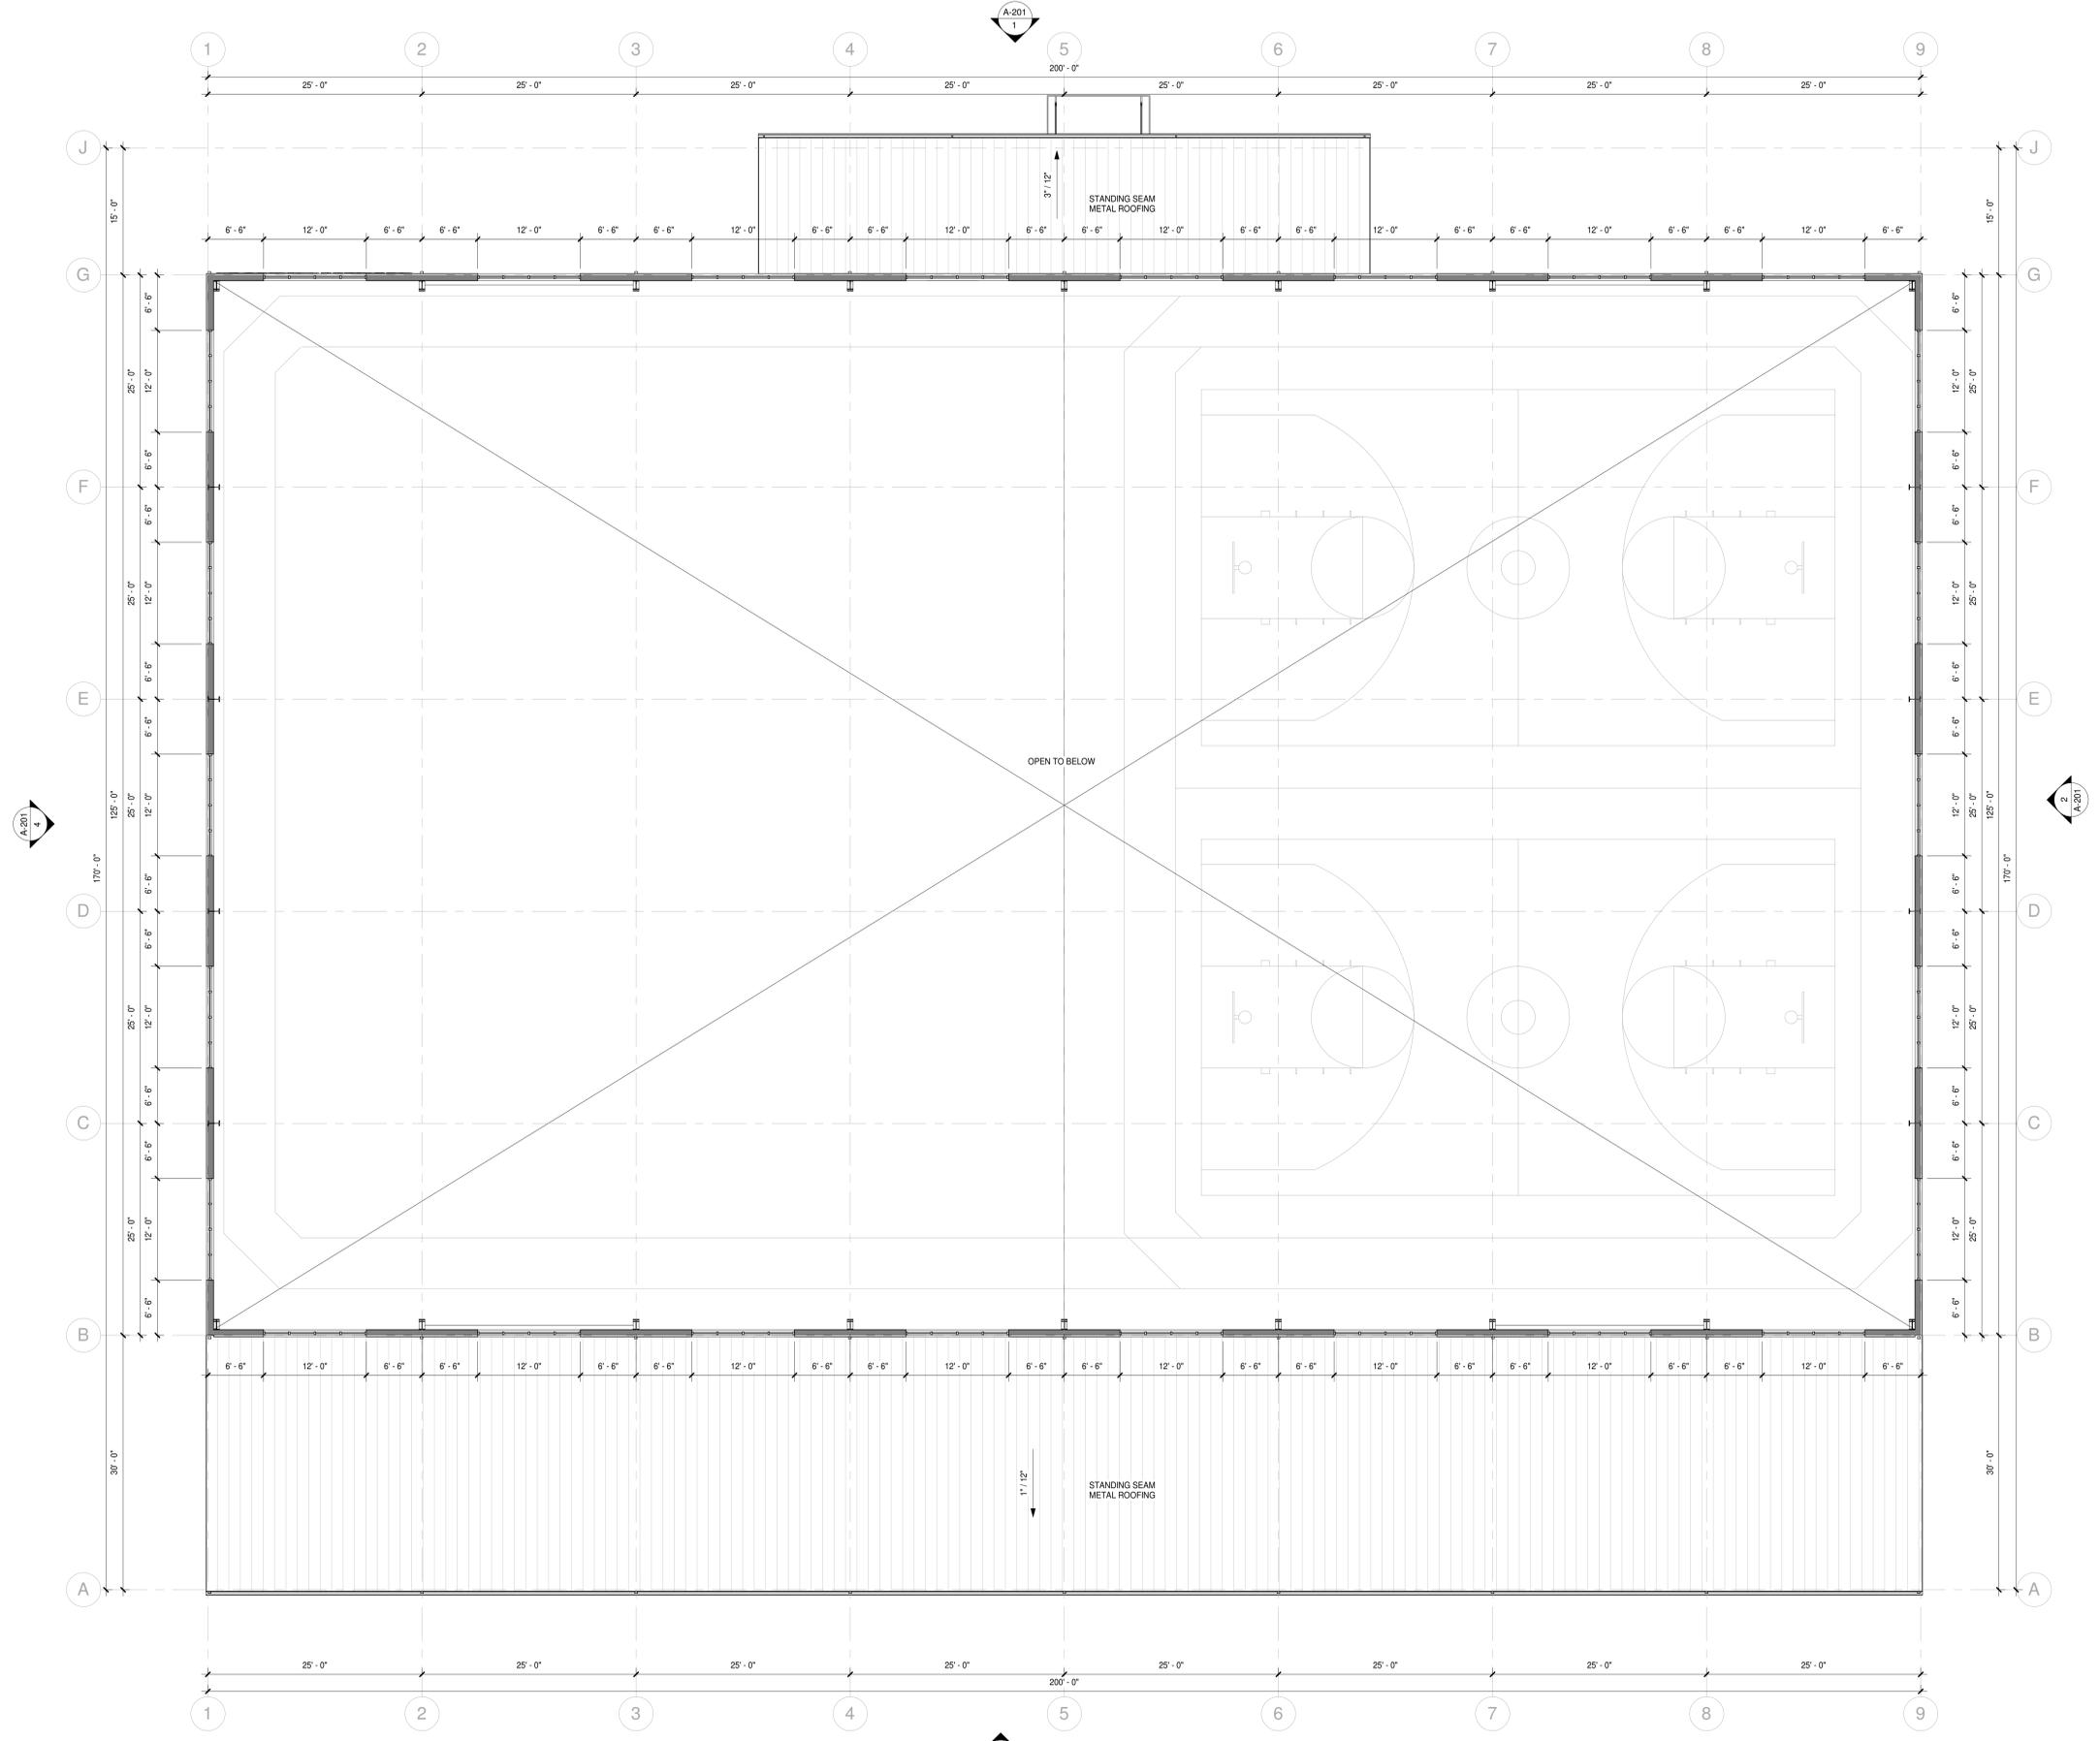

1 UPPER WINDOW PLAN
SCALE: 1/8" = 1'-0"


<p>□ - Preliminary, not for construction, recording purposes or reproduction. □ - Theoretical copy, not for construction. □ - Theoretical copy, not for recording purposes or implementation.</p> <p>DESIGNED/DRAWN BY: JK DATE: 2/11/2026</p>	<p>REVISION BLOCK</p> <table border="1" style="width: 100%; border-collapse: collapse;"> <thead> <tr> <th>No.</th> <th>DATE</th> <th>BY</th> </tr> </thead> <tbody> <tr> <td> </td> <td> </td> <td> </td> </tr> </tbody> </table>	No.	DATE	BY													<p style="text-align: center;">ARCHER-ELGIN ENGINEERING SURVEYING ARCHITECTURE</p> <p style="font-size: small;">CM Archer Group, P.C. dba: ARCHER-ELGIN 310 East 40th Street Suite 1000, Houston TX 77002 Corporate Authority: E-200302812, L.S. 2004017577-D, A-201801179 Phone: 713-564-6027 • www.archer-elgin.com</p>	<p>PROJECT NO: 25142618</p> <p>DRAWING NO: A-102</p>
No.	DATE	BY																
<p>CITY OF HOUSTON BALLPARK QUADPLEX PROJECT</p>		<p>UPPER WINDOW PLAN</p>																

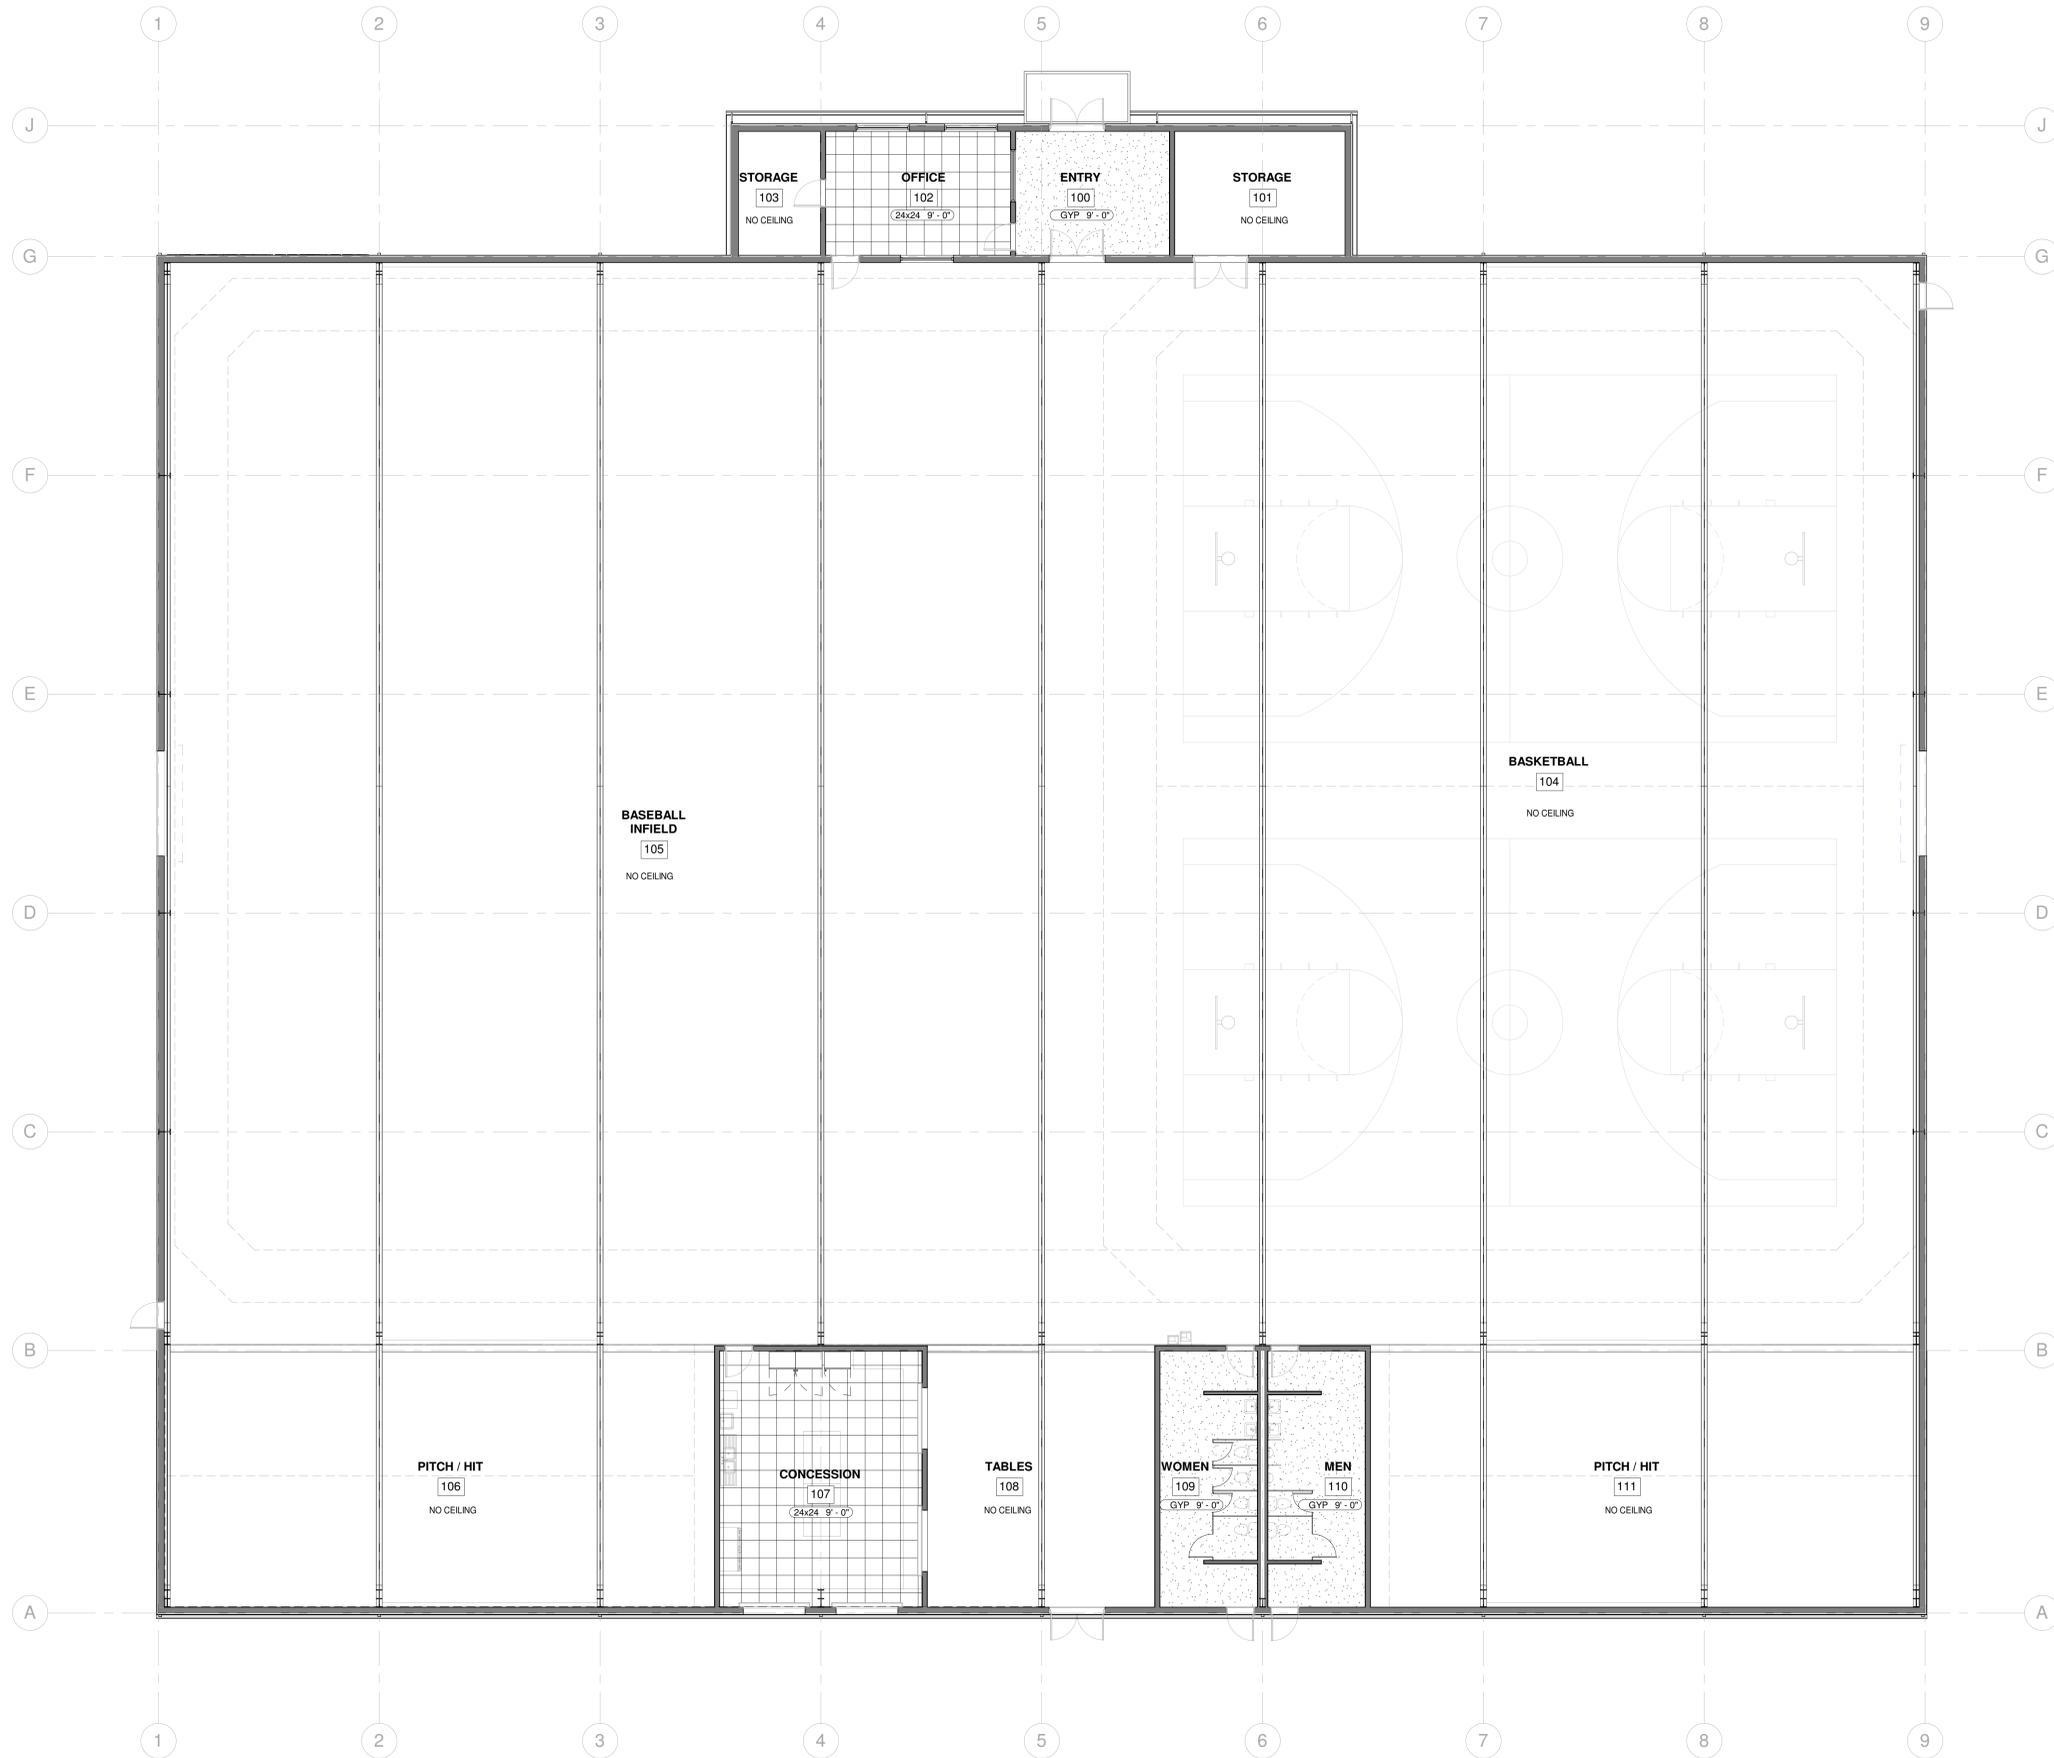

1 REFLECTED CEILING PLAN
SCALE: 1/8" = 1'-0"

PROJECT NO.
25142618
DRAWING NO.
A-151

CITY OF HOUSTON
BALLPARK QUADPLEX PROJECT
REFLECTED CEILING PLAN

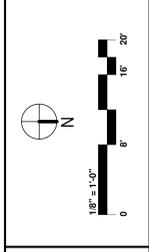


CM Archer Group, P.C. dba:
ARCHER-ELGIN
 ENGINEERING | SURVEYING | ARCHITECTURE
 Corporate Authority:
 CM Archer Group, P.C. E: 2808302812, L.S. 2004017577-A, A-2019011719
 310 East 40th Street Suite, Houston (TX) Phone: 713-264-6322 www.archer-elgin.com

PRELIMINARY DRAWINGS FOR REVIEW AND APPROVAL PURPOSES ONLY. FINAL PLANS WILL BE SIGNED, SEALED, AND APPROVED BY A LICENSED ARCHITECT. APPROVALS FROM LOCAL, STATE, AND FEDERAL REGULATORY AGENCIES.


No.	DATE	BY	REVISION BLOCK

DESIGNED/DRAWN BY: JK
 DATE: 2/11/2026


□ - Preliminary, not for construction, recording purposes or implementation.
 □ - Theoretical, not for construction, recording purposes or implementation.
 □ - Theoretical, not for construction, recording purposes or implementation.

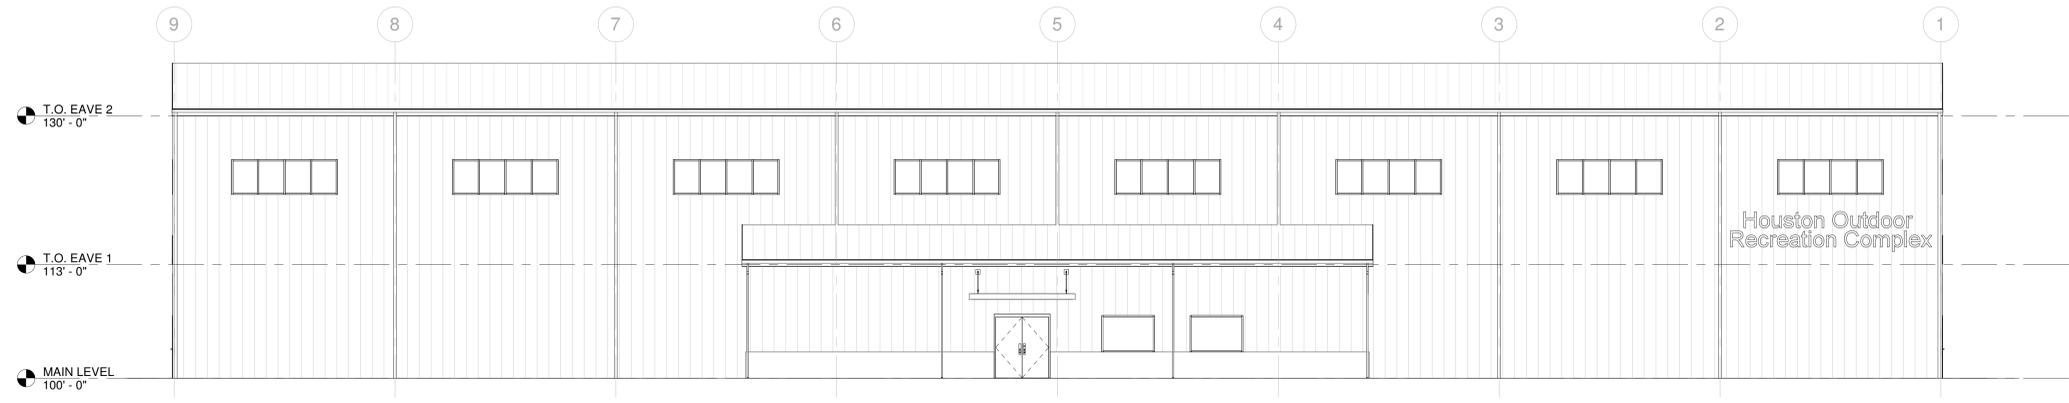


1 WEST ELEVATION
SCALE: 1/8" = 1'-0"

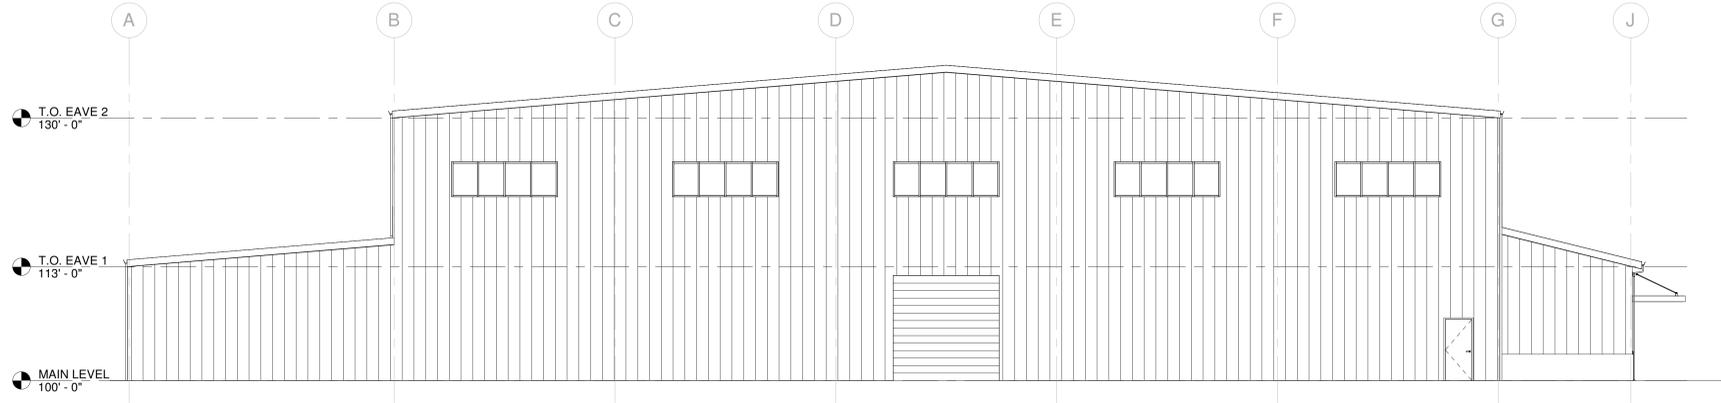

2 NORTH ELEVATION
SCALE: 1/8" = 1'-0"

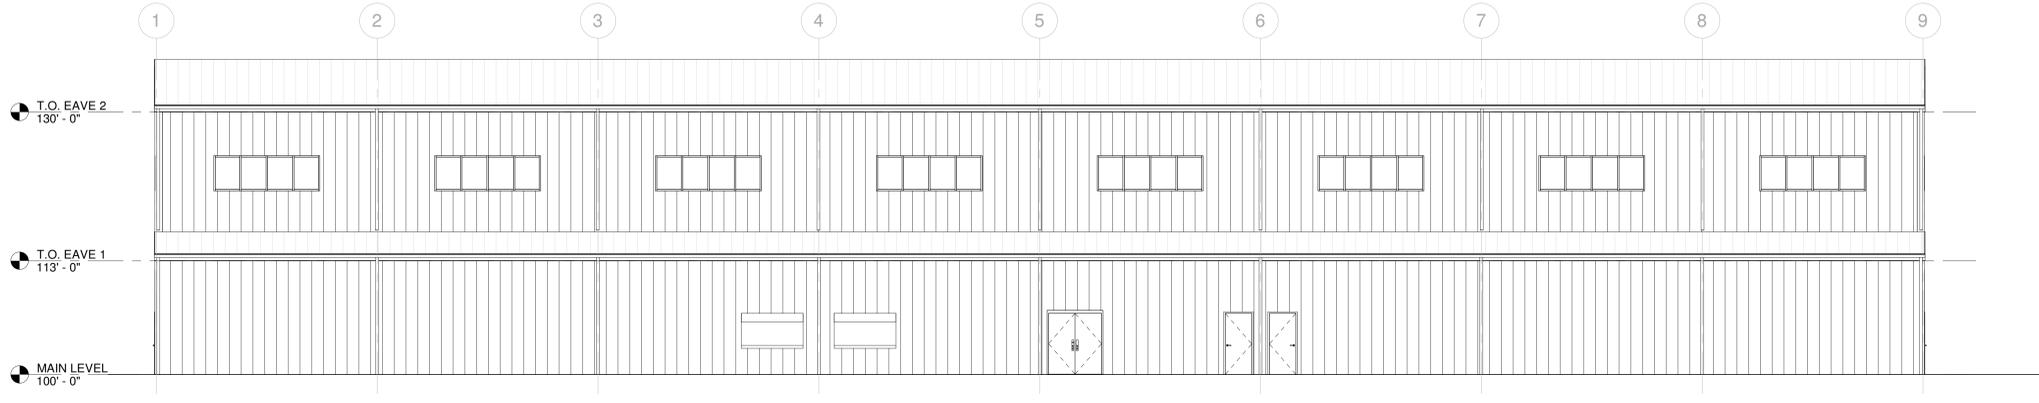


3 EAST ELEVATION
SCALE: 1/8" = 1'-0"

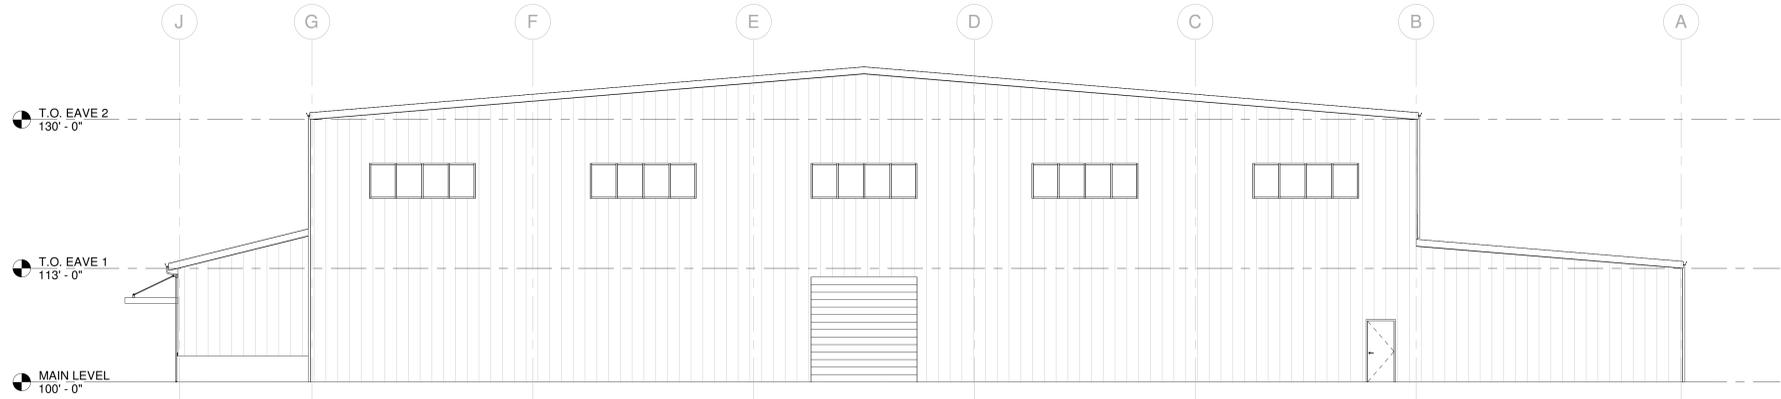

4 SOUTH ELEVATION
SCALE: 1/8" = 1'-0"

 PROJECT NO. 25142618
CITY OF HOUSTON
BALLPARK QUADPLEX PROJECT
DRAWING NO. A-201
EXTERIOR ELEVATIONS



CM Archer Group, P.C. dba:
ARCHER-ELGIN
ENGINEERING | SURVEYING | ARCHITECTURE
Corporate Authority:
CM Archer Group, P.C.: E: 200302812, L.S. 2004017577-D, A-201801179
310 East 40th Street Suite, Missouri 64111 Phone: 314-564-6062 www.archer-elgin.com

PRELIMINARY DRAWINGS FOR REVIEW AND APPROVAL PURPOSES ONLY. FINAL PLANS WILL BE SIGNED, SEALED, AND STAMPED BY THE ARCHITECT. PLAN REVIEW COMMENTS AND APPROVALS FROM LOCAL, STATE, AND FEDERAL REGULATORY AGENCIES.

No.	DATE	BY	REVISION BLOCK

DESIGNED/DRAWN BY: JK
DATE: 2/11/2026
 Preliminary, not for construction, recording purposes or implementation.
 This is a final copy, not for construction, recording purposes or implementation.



<input type="checkbox"/> Preliminary, not for construction, recording purposes or implementation. <input type="checkbox"/> This drawing is a computer-generated copy, not for construction, recording purposes or implementation.		DESIGNED/DRAWN BY: JK DATE: 2/11/2026
No. _____ DATE _____ BY _____		REVISION BLOCK
<p> <input type="checkbox"/> PRELIMINARY DRAWINGS FOR REVIEW AND APPROVAL PURPOSES ONLY. FINAL PLANS WILL BE SIGNED, SEALED, AND STAMPED BY A LICENSED PROFESSIONAL ENGINEER. APPROVALS FROM LOCAL, STATE, AND FEDERAL REGULATORY AGENCIES. </p>		
<p> ARCHER-ELGIN ENGINEERING SURVEYING ARCHITECTURE <small>CM Archer Group, P.C. dba: Archer-Elgin, Inc. Corporate Authority: E: 2003023812, L.S. 2004017577-A, A-2016011719 310 East 40th Street, Suite 1000, Houston, TX 77002 • Phone: 713-264-6322 • www.archer-elgin.com</small> </p>		
CITY OF HOUSTON BALLPARK QUADPLEX PROJECT		PROJECT NO. 25142618 DRAWING NO. A-801
PERSPECTIVE VIEWS		